




WINDOW SCHEDULE				
NO.	QUANTITY	UNIT DIMENSION	TYPE	FRAME
(A)	10	2'-10" x 5'-4"	SINGLE HUNG	VINYL CLAD

DOOR SCHEDULE					
NO.	QUANTITY	SIZE	TYPE	FRAME	REMARKS
(3)	1	3'-0" x 6'-8"	SOLID WOOD FIRE RATED	METAL	HINGES, LEVER HARDWARE, CLOSER, 1-HR FIRE RATED, PASSAGE LOCKSET
(5)	1	3'-0" x 6'-8"	SOLID WOOD	METAL	HINGES, LEVER HARDWARE, PRIVACY LOCKSET
(6)	1	3'-6" x 6'-8"	METAL INSULATED	METAL	HINGES, EXTERIOR LEVER HARDWARE, INTERIOR PANIC HARDWARE, CLOSER, ENTRY LOCKSET, THRESHOLD
(7)	1	2'-10" x 6'-8"	SOLID WOOD FIRE RATED	METAL	HINGES, LEVER HARDWARE, PANIC HARDWARE, CLOSER, 1-HR FIRE RATED, PASSAGE LOCKSET

- PLAN SUBMISSION NOTES**
- THIS PLAN IS FOR CITY OF HALLOWELL BUILDING CODE, LIFE SAFETY CODE, ADA, FIRE MARSHAL AND OCCUPANCY APPROVAL ONLY.
  - PLAN BASED ON PLAN PROVIDED BY THE OWNER.
  - THE PLUMBING, ELECTRICAL, AND MECHANICAL DESIGN OF THE BUILDING IS BY THE OWNER.
  - IBC 2009 USE GROUP: BUSINESS (B)
  - 2009 NFPA LIFE SAFETY OCCUPANCY: BUSINESS
  - CONSTRUCTION TYPE: TYPE V B (UNPROTECTED)

**LEGEND**

	EXISTING WALL
	PROPOSED WALL
	1-HR. FIRE RATED WALL
	2-HR. FIRE RATED WALL
	EXIT SIGN
	EMERGENCY LIGHTING
	SMOKE DETECTOR
	FIRE ALARM PULL HANDLE
	HEAT DETECTOR
	HORN/STROBE LIGHT
	FIRE EXTINGUISHER
	BRAILLE SIGNAGE

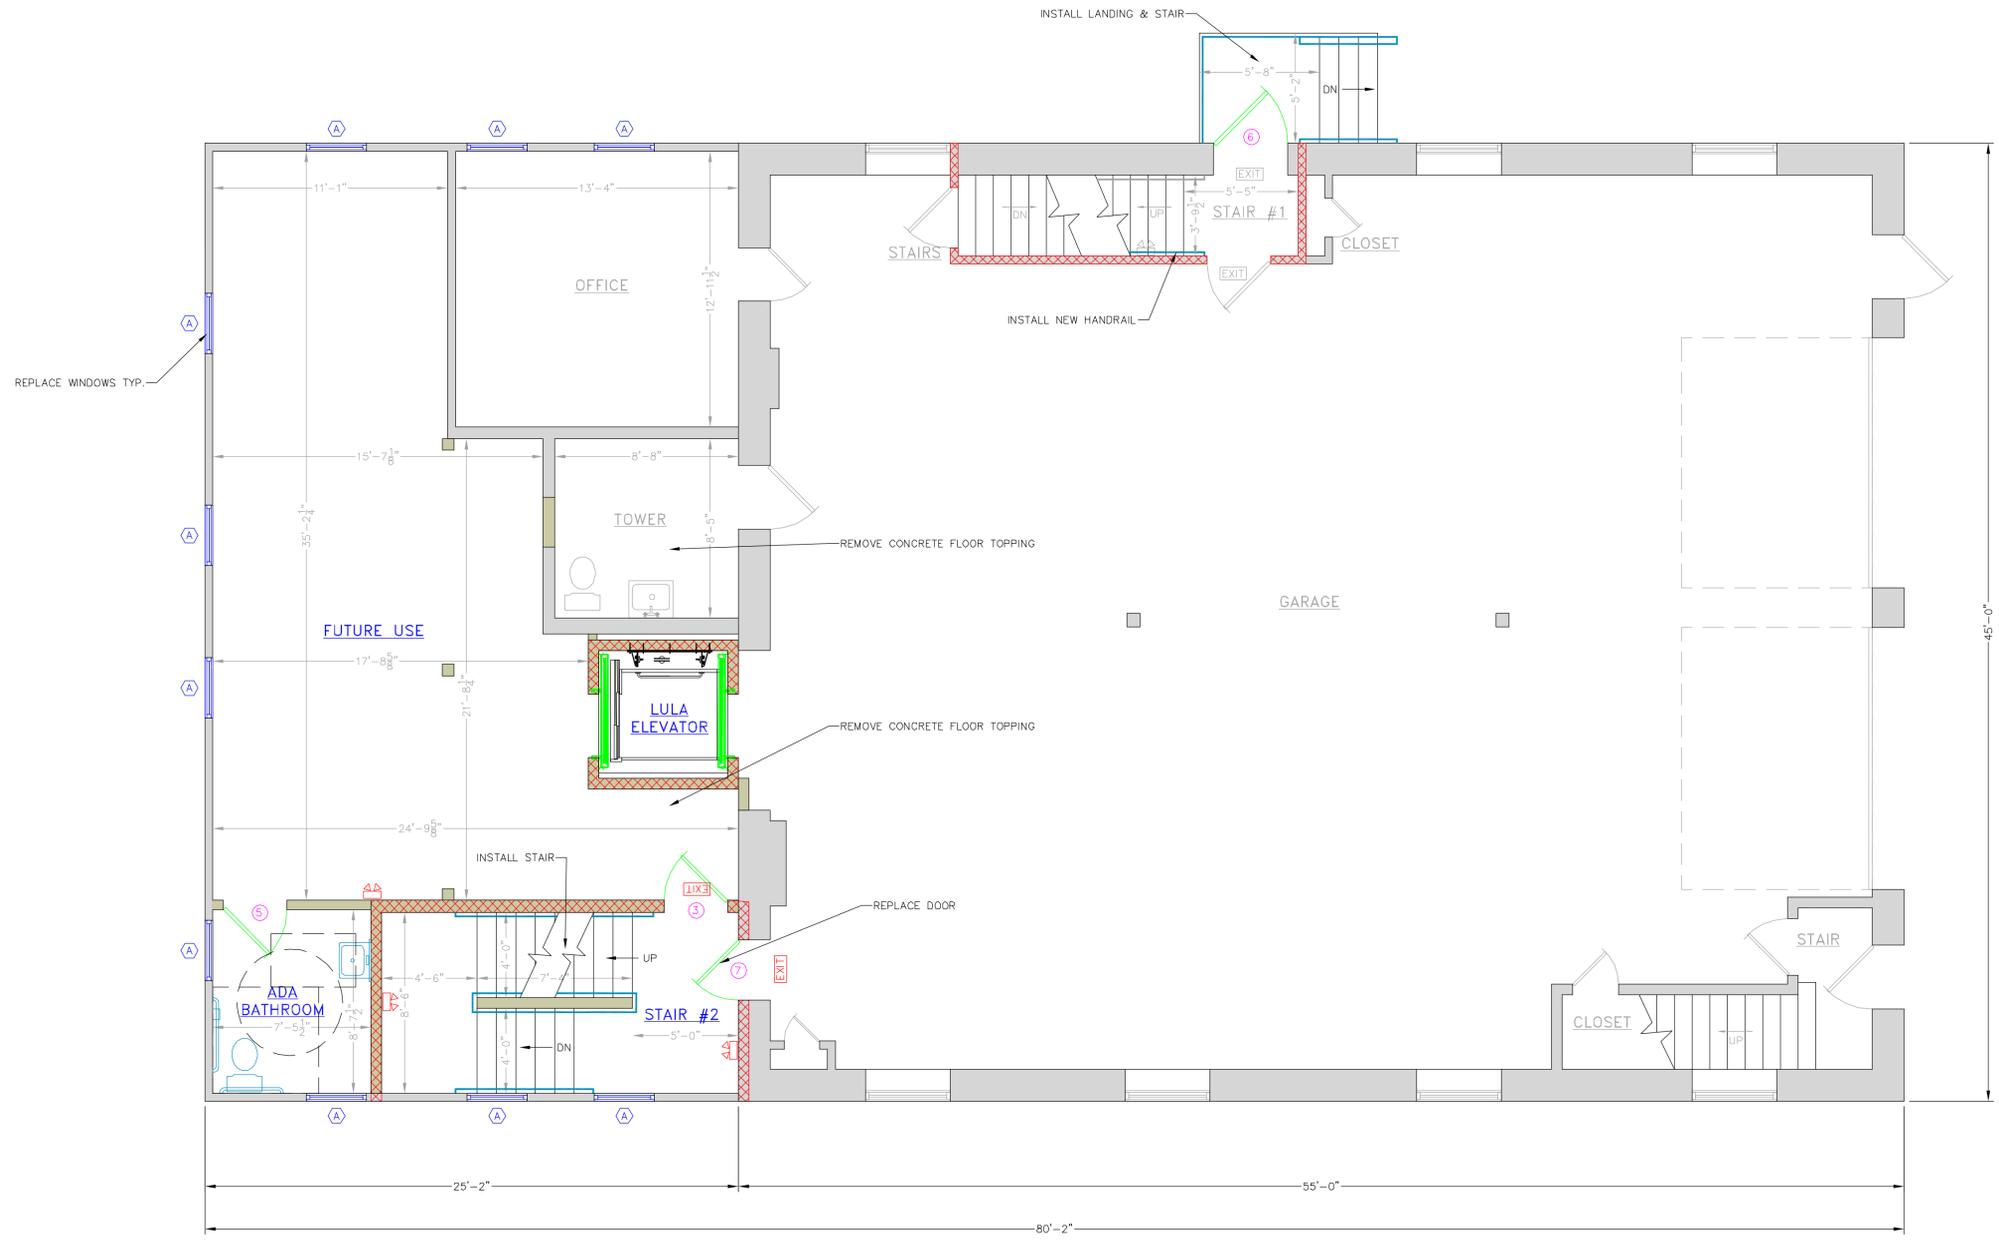

**FIRST FLOOR PLAN**  
SCALE 1/4" = 1'-0"

ADVANCE COPY

**E.S. COFFIN**  
ENGINEERING & SURVEYING  
432 Com. Road P.O. Box 4687 Augusta, Maine 04330  
Ph. (207) 623-9475 Fax (207) 623-9016 Toll Free 1-800-244-9475


NO.	REVISIONS	DATE

CLIENT & PROJECT	CITY OF HALLOWELL HALLOWELL FIRE STATION
LOCATION	124 SECOND STREET
TOWN	HALLOWELL
COUNTY	KENNEBEC
STATE	MAINE
SHEET TITLE	FIRST FLOOR PLAN
SCALE	1/4" = 1'-0"
DATE	NOVEMBER 15, 2016
DRAWN BY	JPK
CHECKED BY	BEM

PROJ. NO. 2015-252

**A-2**



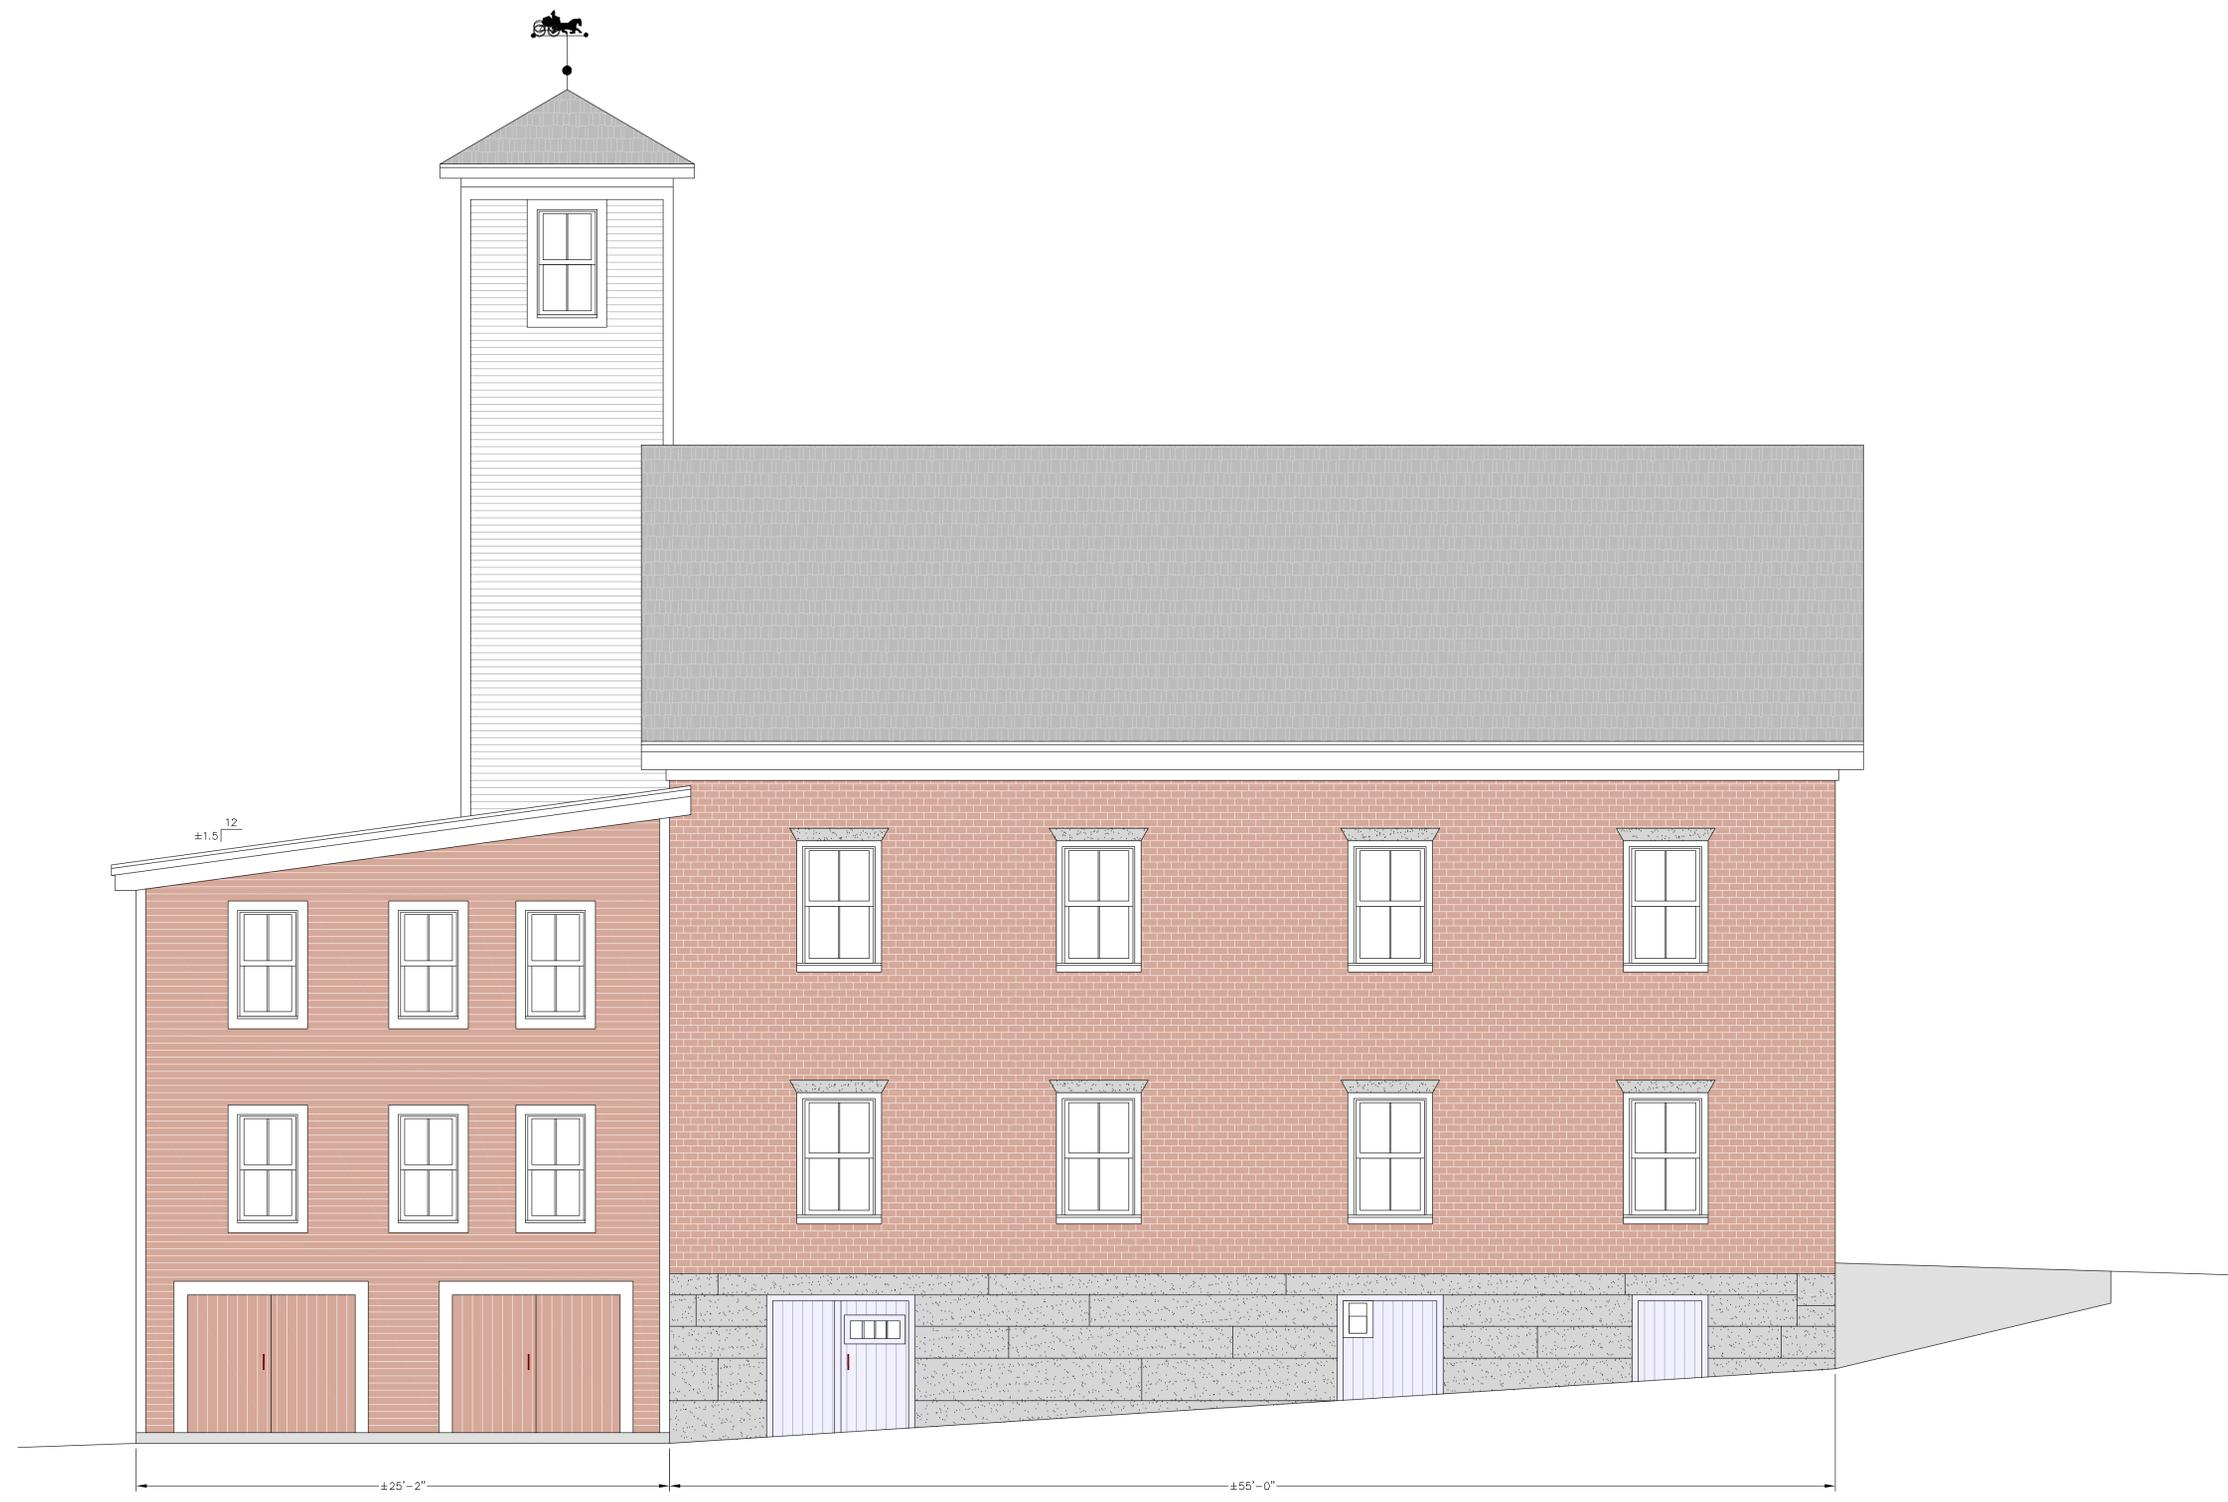

EXISTING NORTH ELEVATION  
SCALE 1/4" = 1'-0"

ADVANCE COPY




NO.	REVISIONS	DATE

CLIENT & PROJECT <b>CITY OF HALLOWELL HALLOWELL FIRE STATION</b>	SHEET TITLE <b>EXISTING NORTH ELEVATION</b>
LOCATION: 124 SECOND STREET	SCALE: 1/4" = 1'-0"
TOWN: HALLOWELL COUNTY: KENNEBEC STATE: MAINE	DATE: NOVEMBER 15, 2016
	DRAWN BY: JPK CHECKED BY: BEM

PROJ. NO. 2015-252

**A-4**

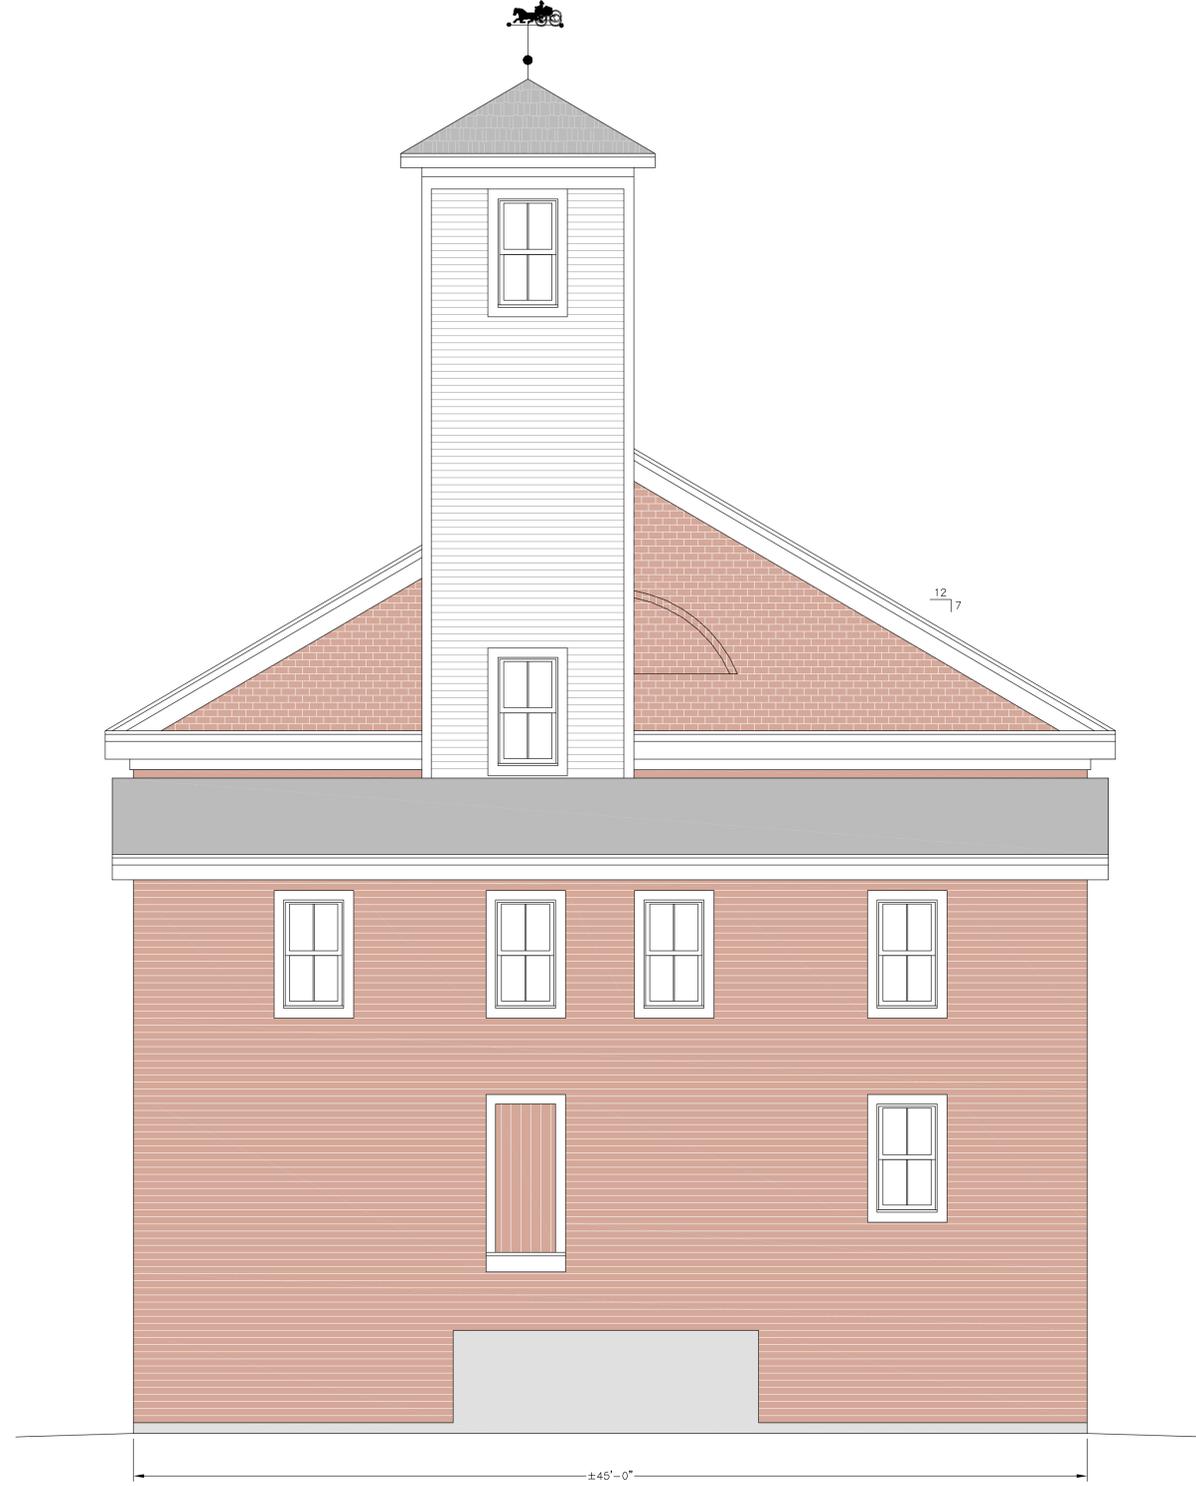

EXISTING EAST ELEVATION  
SCALE 1/4" = 1'-0"

ADVANCE  
COPY



NO.	REVISIONS	DATE

CLIENT & PROJECT <b>CITY OF HALLOWELL</b> <b>HALLOWELL FIRE STATION</b>	SHEET TITLE: <b>EXISTING EAST ELEVATION</b>	
	LOCATION: 124 SECOND STREET TOWN: HALLOWELL COUNTY: KENNEBEC STATE: MAINE	SCALE: 1/4" = 1'-0" DATE: NOVEMBER 15, 2016 DRAWN BY: JPK CHECKED BY: BEM

PROJ. NO. 2015-252

**A-5**



PROPOSED NORTH ELEVATION  
SCALE 1/4" = 1'-0"

ADVANCE COPY



NO.	REVISIONS	DATE

CLIENT & PROJECT <b>CITY OF HALLOWELL HALLOWELL FIRE STATION</b>	SHEET TITLE: <b>PROPOSED NORTH ELEVATION</b>	
	LOCATION: 124 SECOND STREET	SCALE: 1/4" = 1'-0"
TOWN: HALLOWELL COUNTY: KENNEBEC STATE: MAINE	DATE: NOVEMBER 15, 2016	DRAWN BY: JPK CHECKED BY: BEM

PROJ. NO. 2015-252

**A-6**



PROPOSED EAST ELEVATION  
SCALE 1/4" = 1'-0"

ADVANCE  
COPY



NO.	REVISIONS	DATE


CLIENT & PROJECT: <b>CITY OF HALLOWELL HALLOWELL FIRE STATION</b>	SHEET TITLE: <b>PROPOSED EAST ELEVATION</b>
LOCATION: <b>124 SECOND STREET</b>	SCALE: <b>1/4" = 1'-0"</b>
TOWN: <b>HALLOWELL</b> COUNTY: <b>KENNEBEC</b> STATE: <b>MAINE</b>	DATE: <b>NOVEMBER 15, 2016</b>
	DRAWN BY: <b>JPK</b> CHECKED BY: <b>BEM</b>









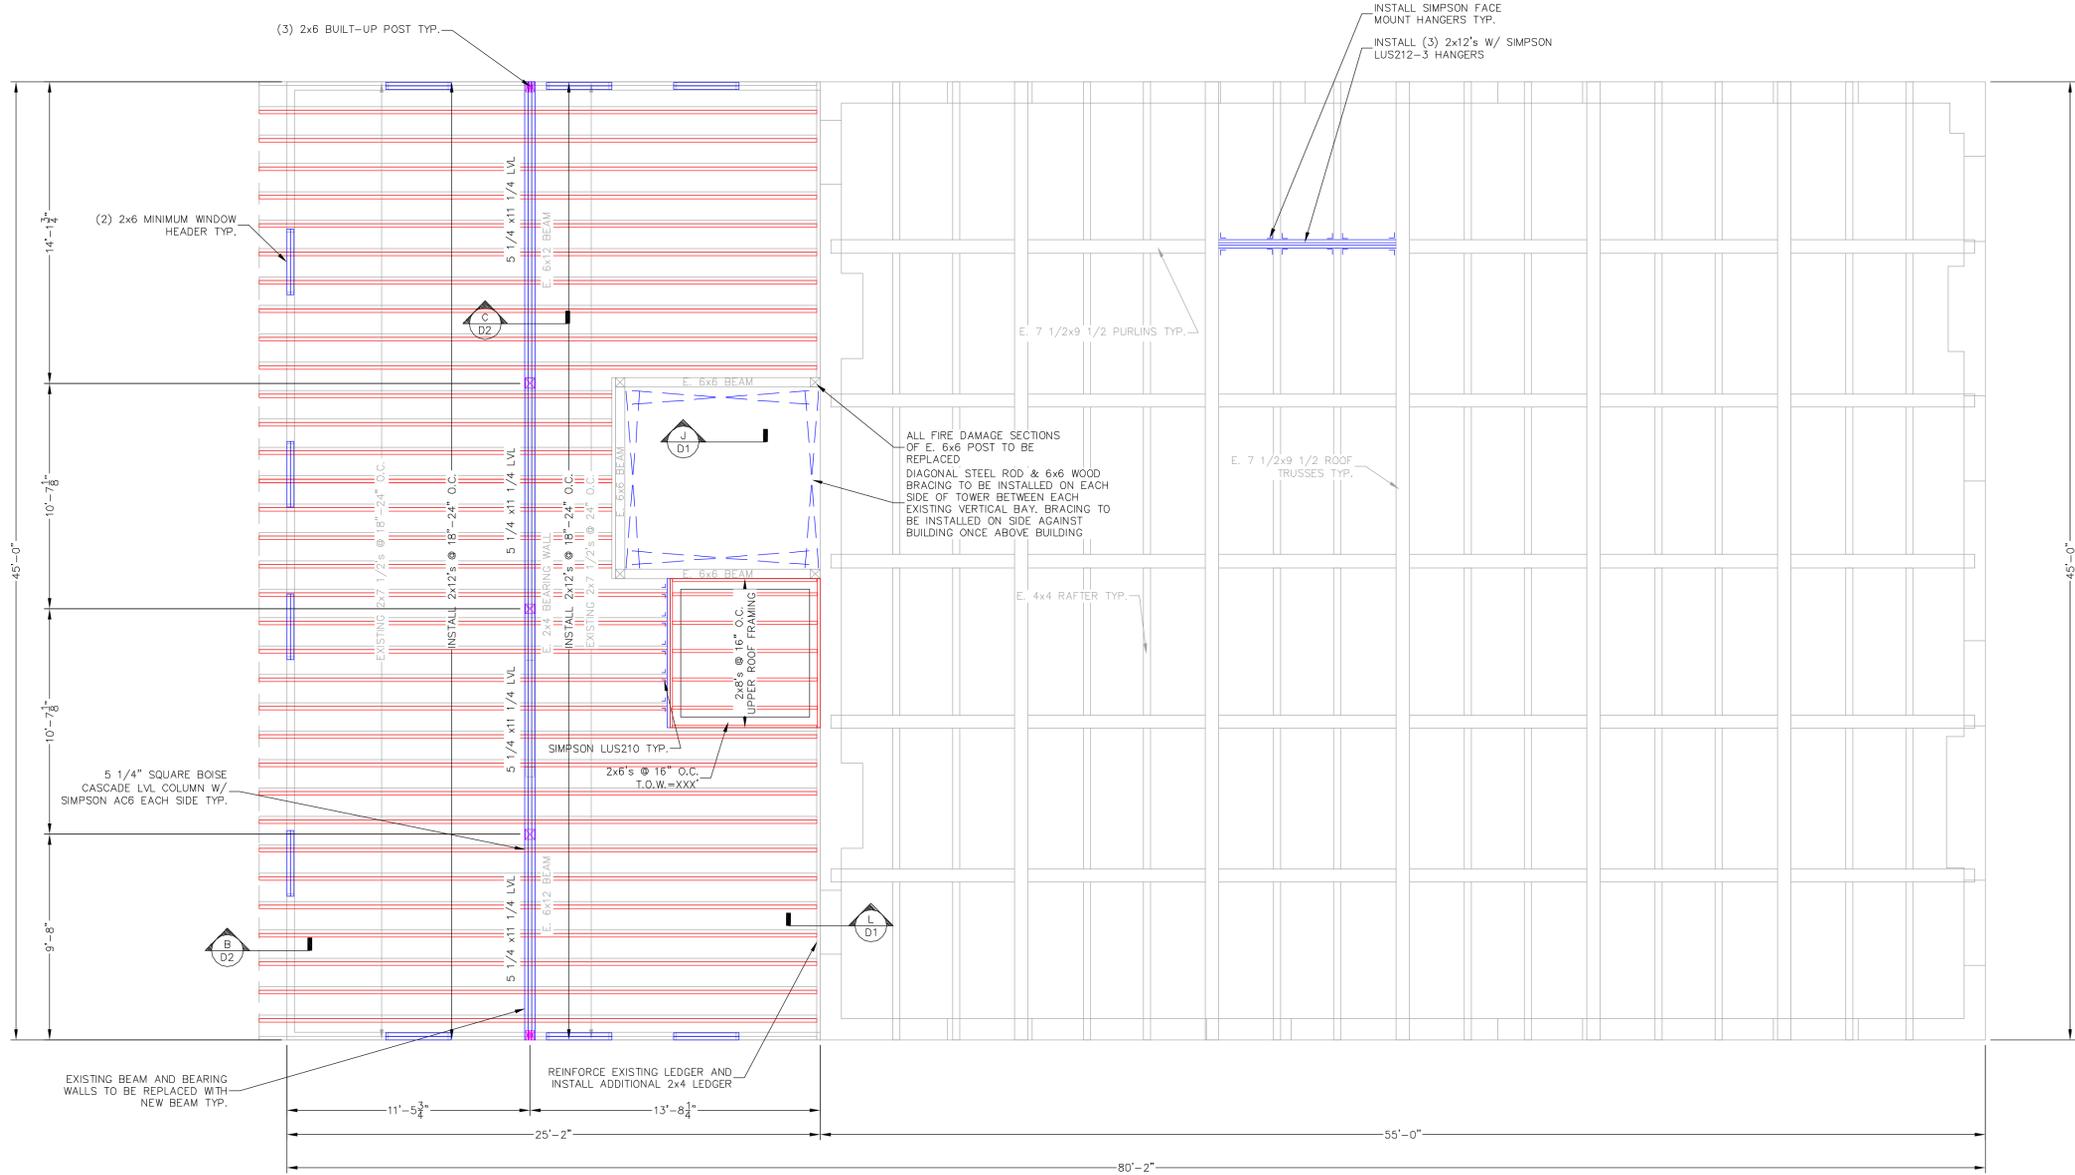

NO.	REVISIONS	DATE

<b>CLIENT &amp; PROJECT</b>	<b>ROOF FRAMING PLAN</b>
<b>CITY OF HALLOWELL</b>	
<b>HALLOWELL FIRE STATION</b>	
<b>LOCATION: 124 SECOND STREET</b>	
<b>TOWN: HALLOWELL COUNTY: KENNEBEC STATE: MAINE</b>	
<b>SCALE: 1/4" = 1'-0"</b>	<b>DRAWN BY: JPK</b>
<b>DATE: NOVEMBER 15, 2016</b>	<b>CHECKED BY: BEM</b>


**ROOF FRAMING PLAN**  
 SCALE 1/4" = 1'-0"

NO.	REVISIONS	DATE


NO.	REVISIONS	DATE

CLIENT & PROJECT	CITY OF HALLOWELL HALLOWELL FIRE STATION
LOCATION	124 SECOND STREET
TOWN	HALLOWELL
COUNTY	KENNEBEC
STATE	MAINE
SCALE	AS SHOWN
DATE	NOVEMBER 15, 2016
DRAWN BY	JPK
CHECKED BY	BEM


PROJ. NO. 2015-252

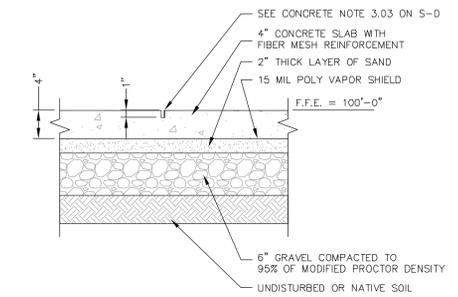


D SECTION  
S1 SCALE 1" = 1'-0"

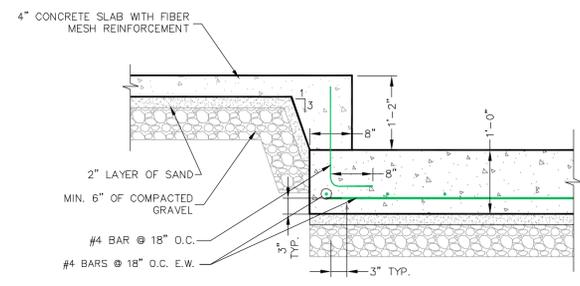


C SECTION  
S1 SCALE 3/4" = 1'-0"

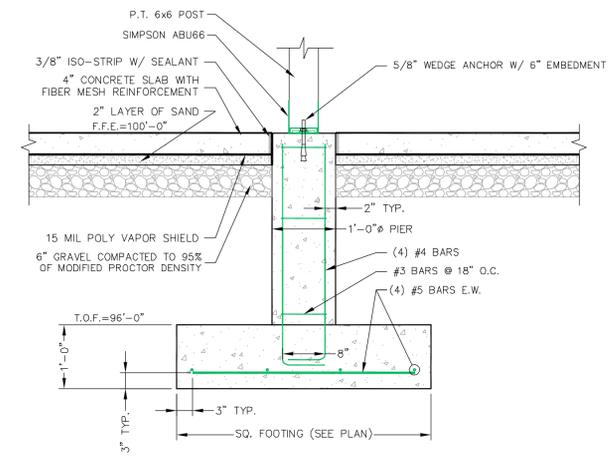


B SECTION  
S1 SCALE 3/4" = 1'-0"

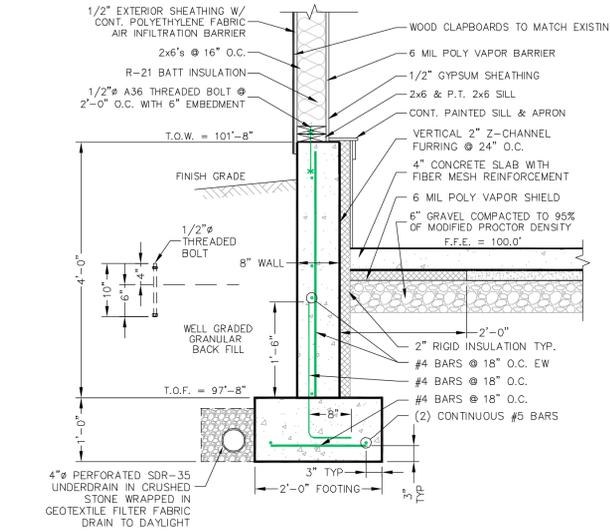


A SECTION  
S1 SCALE 3/4" = 1'-0"

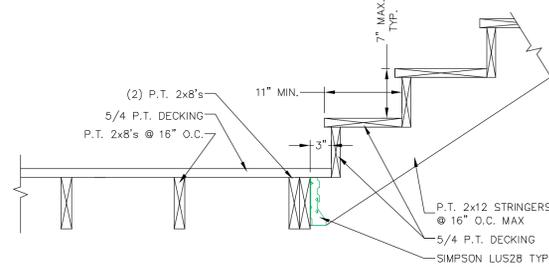


H SECTION  
S2 SCALE 1" = 1'-0"

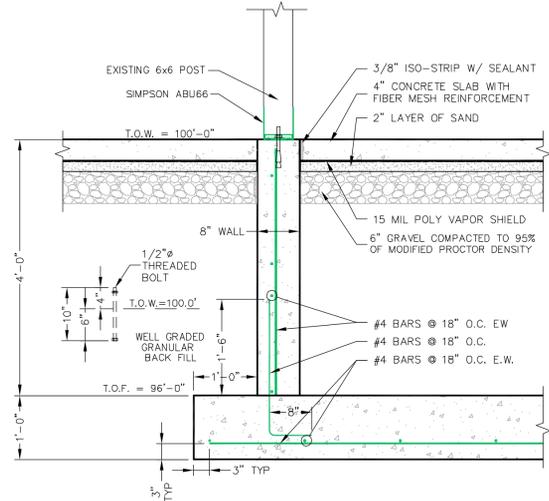


G SECTION  
S1 SCALE 3/4" = 1'-0"

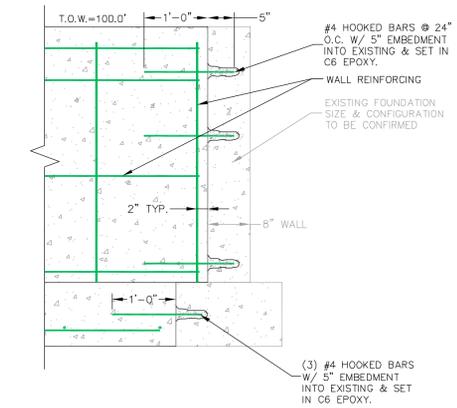


F SECTION  
S1 SCALE 3/4" = 1'-0"

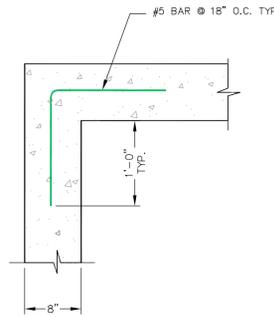


E SECTION  
S1 SCALE 1" = 1'-0"

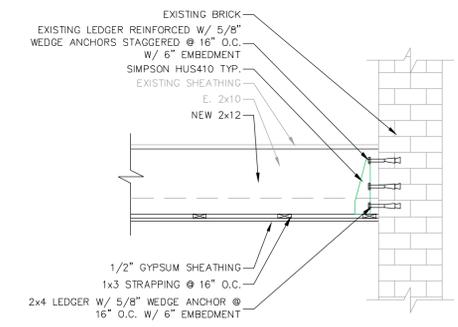


L SECTION  
S2 S3 S4 SCALE 3/4" = 1'-0"

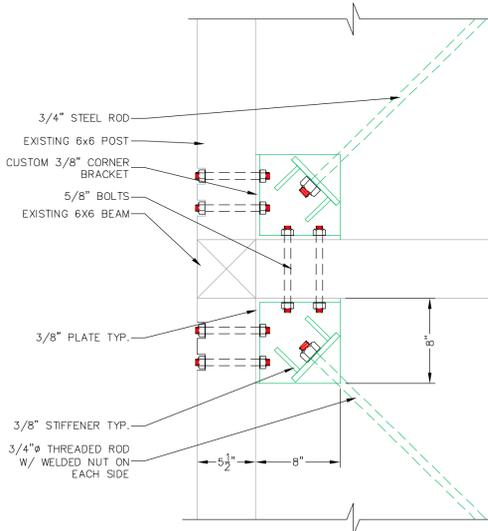


K SECTION  
D1 SCALE 1 1/2" = 1'-0"

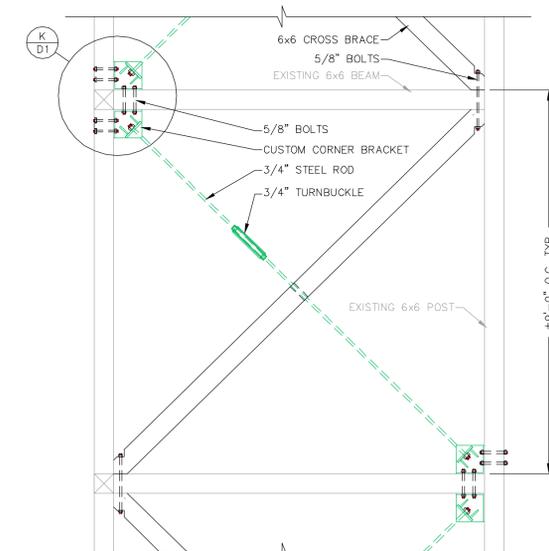


J SECTION  
S3 S4 SCALE 1/2" = 1'-0"

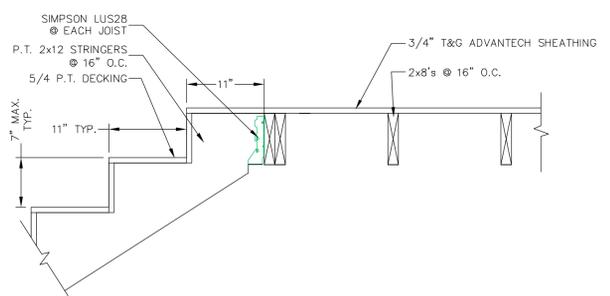


I SECTION  
S2 S3 SCALE 1" = 1'-0"

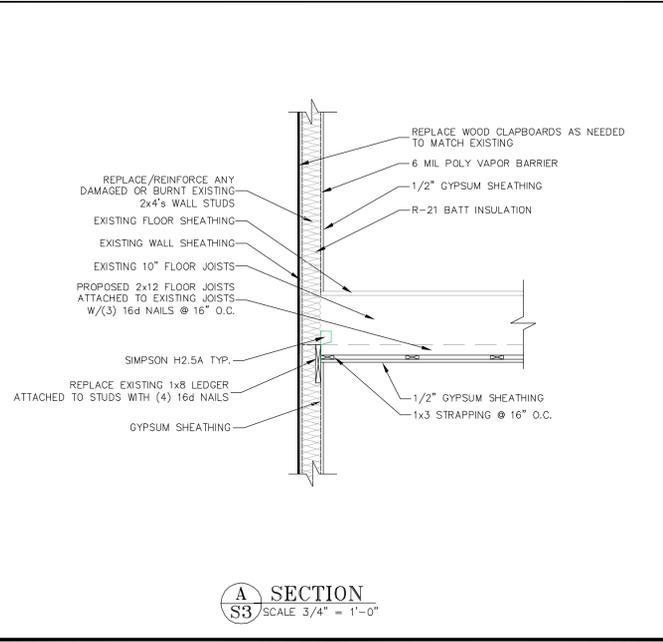

**A**  
**S3** SECTION  
SCALE 3/4" = 1'-0"

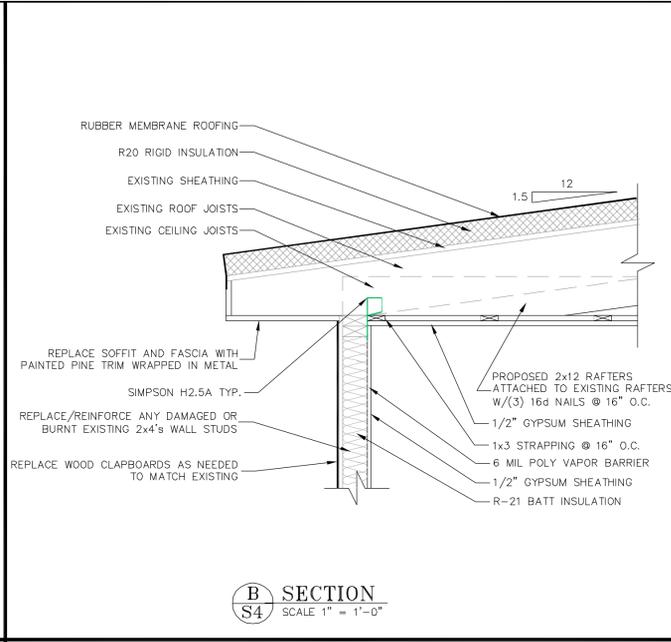

**B**  
**S4** SECTION  
SCALE 1" = 1'-0"

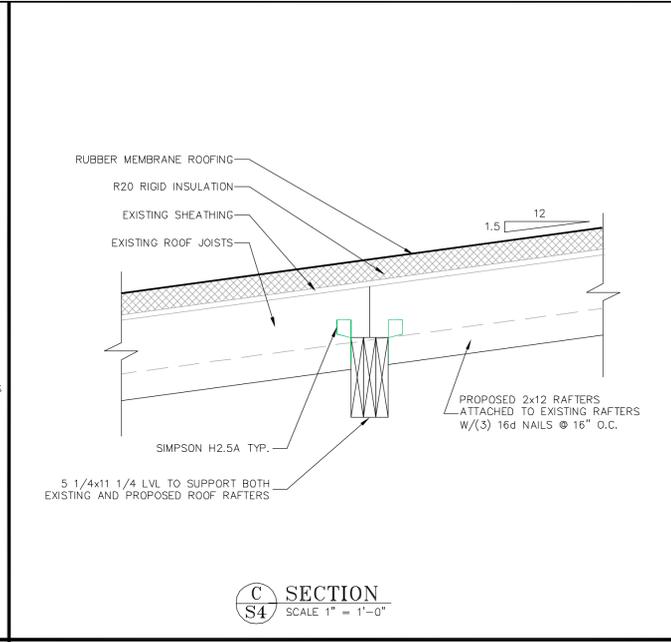

**C**  
**S4** SECTION  
SCALE 1" = 1'-0"

NO.	REVISIONS	DATE

<b>DETAILS</b>	SHHEET TITLE:
	SCALE: AS SHOWN
CITY OF HALLOWELL HALLOWELL FIRE STATION	DATE: NOVEMBER 15, 2016
	DRAWN BY: JPK CHECKED BY: BEM
LOCATION: 124 SECOND STREET	STATE: MAINE
TOWN: HALLOWELL	COUNTY: KENNEBEC

PROJ. NO. 2015-252